

INDEX OF PLANS

| SHEET NO. | DESCRIPTION                                |
|-----------|--|
| 1         | TITLE SHEET AND LOCATION MAP               |
| 2         | KEY MAP AND LINE INDEX                     |
| 3         | WATER QUALITY POLLUTION CONTROL QUANTITIES |
| 4-65      | UTILITY PLANS                              |
| 66        | CONSTRUCTION AREA SIGNS                    |
| 67        | EROSION CONTROL LEGEND AND QUANTITIES      |
| 68-175    | ELECTRICAL PLANS                           |

THE STANDARD PLANS LIST APPLICABLE TO THIS CONTRACT IS INCLUDED IN THE NOTICE TO BIDDERS AND SPECIAL PROVISIONS. BOOK.


**STATE OF CALIFORNIA**  
**DEPARTMENT OF TRANSPORTATION**  
**PROJECT PLANS FOR CONSTRUCTION ON**  
**STATE HIGHWAY**  
**IN ALAMEDA AND CONTRA COSTA COUNTIES**  
**ON ROUTE 680 FROM ROUTE 580 TO**  
**BENICIA BRIDGE TOLL PLAZA**  
**AND VARIOUS LOCATIONS**

TO BE SUPPLEMENTED BY STANDARD PLANS DATED 2010

|      |         |       |                          |           |              |
|------|---------|-------|--------------------------|-----------|--------------|
| Dist | COUNTY  | ROUTE | POST MILES TOTAL PROJECT | SHEET No. | TOTAL SHEETS |
| 04   | Ala, CC | 680   | 20.2/21.9<br>0.0/24.6    | 1         | 175          |

**Caltrans**

APPROVED AS TO IMPACT ON STATE FACILITIES AND CONFORMANCE WITH APPLICABLE STATE STANDARDS AND PRACTICES AND THAT TECHNICAL OVERSIGHT WAS PERFORMED.  
 DATE SIGNED \_\_\_\_\_  
 LICENSE Exp DATE \_\_\_\_\_  
 REGISTRATION No. \_\_\_\_\_  
 CALTRANS DESIGN OVERSIGHT APPROVAL \_\_\_\_\_  
 CONSULTANT DESIGN ENGINEER ARON ZEREZCHI

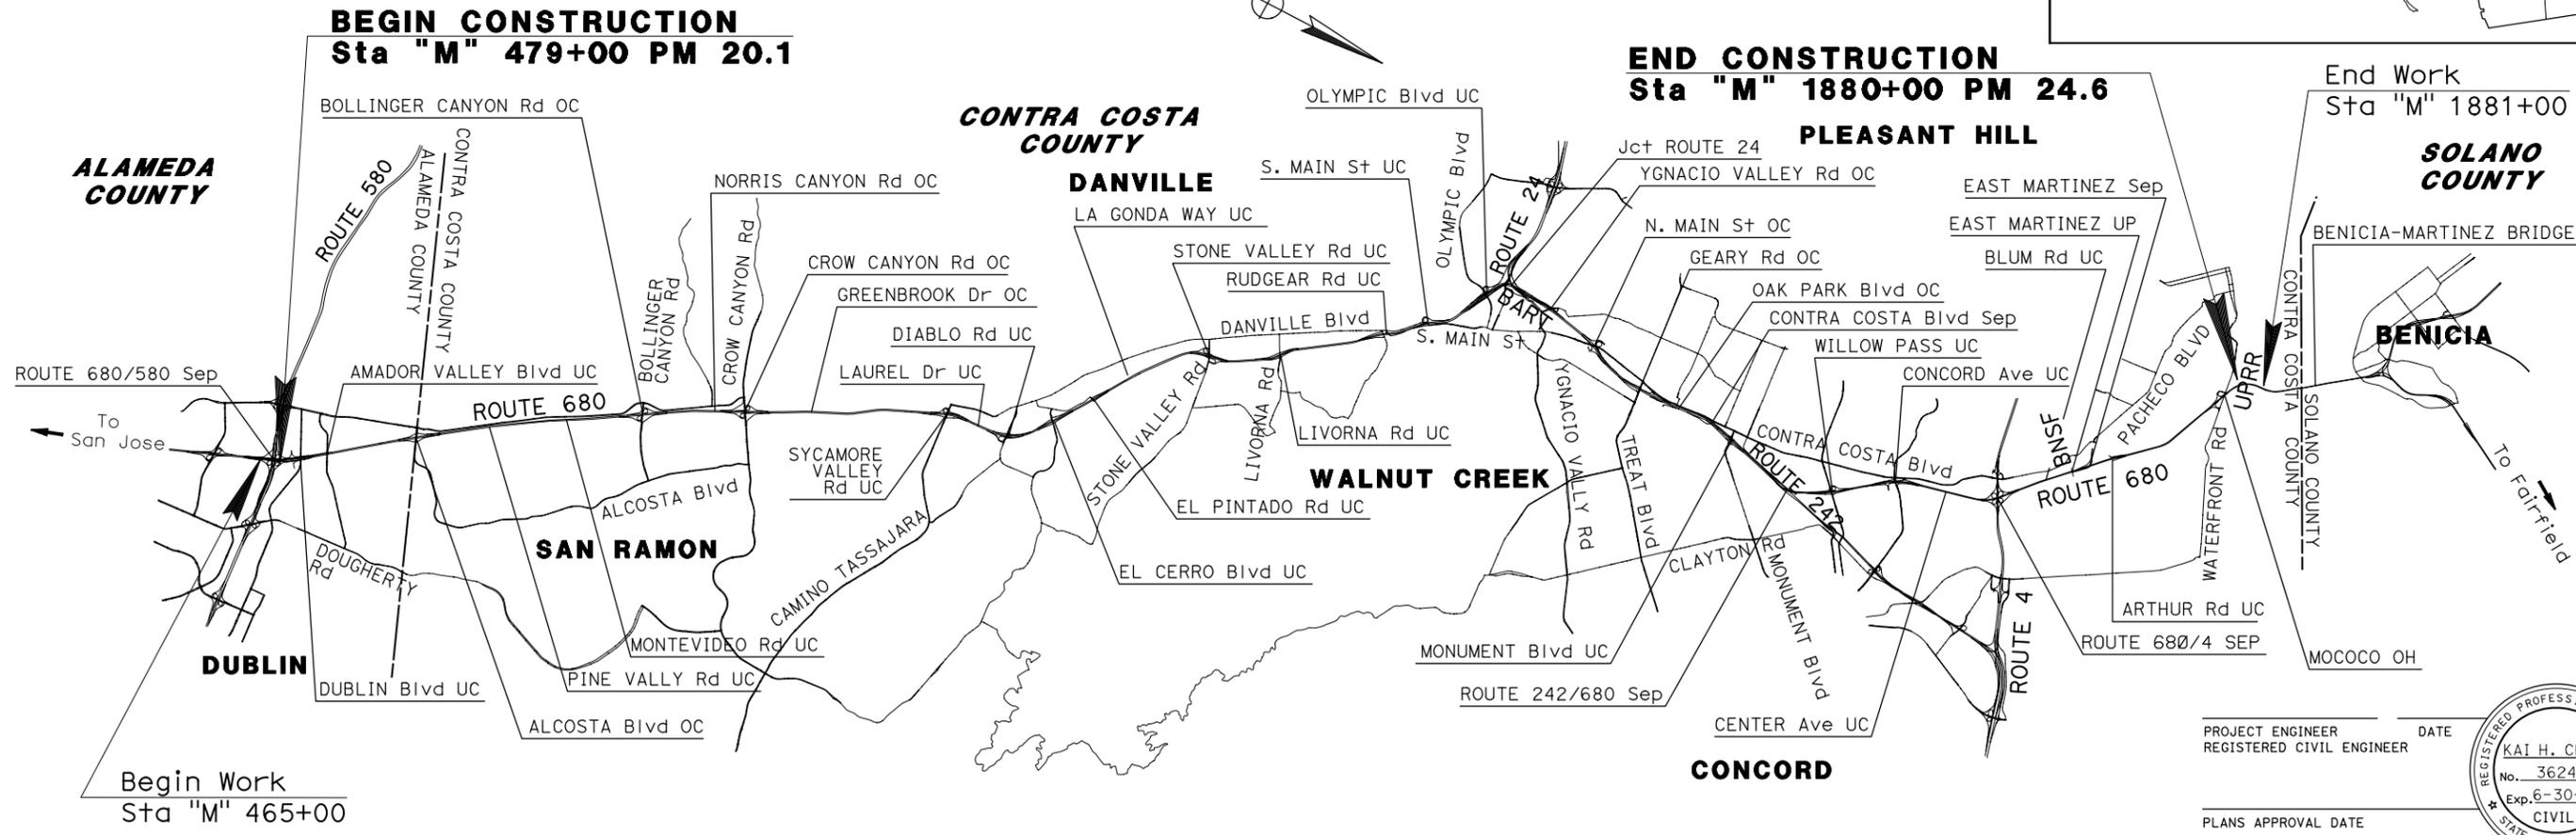

PROJECT ENGINEER DATE  
 REGISTERED CIVIL ENGINEER  
  
 PLANS APPROVAL DATE  
 THE STATE OF CALIFORNIA OR ITS OFFICERS OR AGENTS SHALL NOT BE RESPONSIBLE FOR THE ACCURACY OR COMPLETENESS OF SCANNED COPIES OF THIS PLAN SHEET.

ATKINS  
 332 PINE STREET  
 5TH FLOOR  
 SAN FRANCISCO, CA 94104  
 METROPOLITAN TRANSPORTATION COMMISSION  
 101 EIGHTH STREET  
 OAKLAND, CA 94607  
 CONTRACT No. **04-2J3304**  
 PROJECT ID **0414000490**

THE CONTRACTOR SHALL POSSESS THE CLASS (OR CLASSES) OF LICENSE AS SPECIFIED IN THE "NOTICE TO BIDDERS."

NO SCALE

RELATIVE BORDER SCALE 0 1 2 3 USERNAME => \$USER DGN FILE => \$REQUEST

BORDER LAST REVISED 10/4/2013 CALTRANS WEB SITE IS: HTTP://WWW.DOT.CA.GOV/

UNIT 0750 PROJECT NUMBER & PHASE 0414000490

LAST REVISION 00-00-00  
 DATE PLOTTED => \$DATE  
 TIME PLOTTED => \$TIME