

INDEX OF PLANS

SHEET NO.	DESCRIPTION
1	TITLE SHEET AND LOCATION MAP
2-3	KEY MAP AND LINE INDEX
4-113	UTILITY PLANS
114	CONSTRUCTION AREA SIGNS
115	SIGN DETAILS
116	EROSION CONTROL LEGEND AND QUANTITIES
117-247	ELECTRICAL PLANS


THE STANDARD PLANS LIST APPLICABLE TO THIS CONTRACT IS INCLUDED IN THE NOTICE TO BIDDERS AND SPECIAL PROVISIONS. BOOK.

STATE OF CALIFORNIA
DEPARTMENT OF TRANSPORTATION
PROJECT PLANS FOR CONSTRUCTION ON
STATE HIGHWAY
IN SANTA CLARA AND ALAMEDA COUNTIES
ON ROUTE 880 FROM CALAVERAS
BOULEVARD TO 0.6 MILES NORTH OF
HEGENBERGER ROAD

TO BE SUPPLEMENTED BY STANDARD PLANS DATED 2010

Dist	COUNTY	ROUTE	POST MILES TOTAL PROJECT	SHEET No.	TOTAL SHEETS
04	San, Alameda, Solano	880	8.4/10.5 0.00/26.1	XX	XX

LOCATION MAP

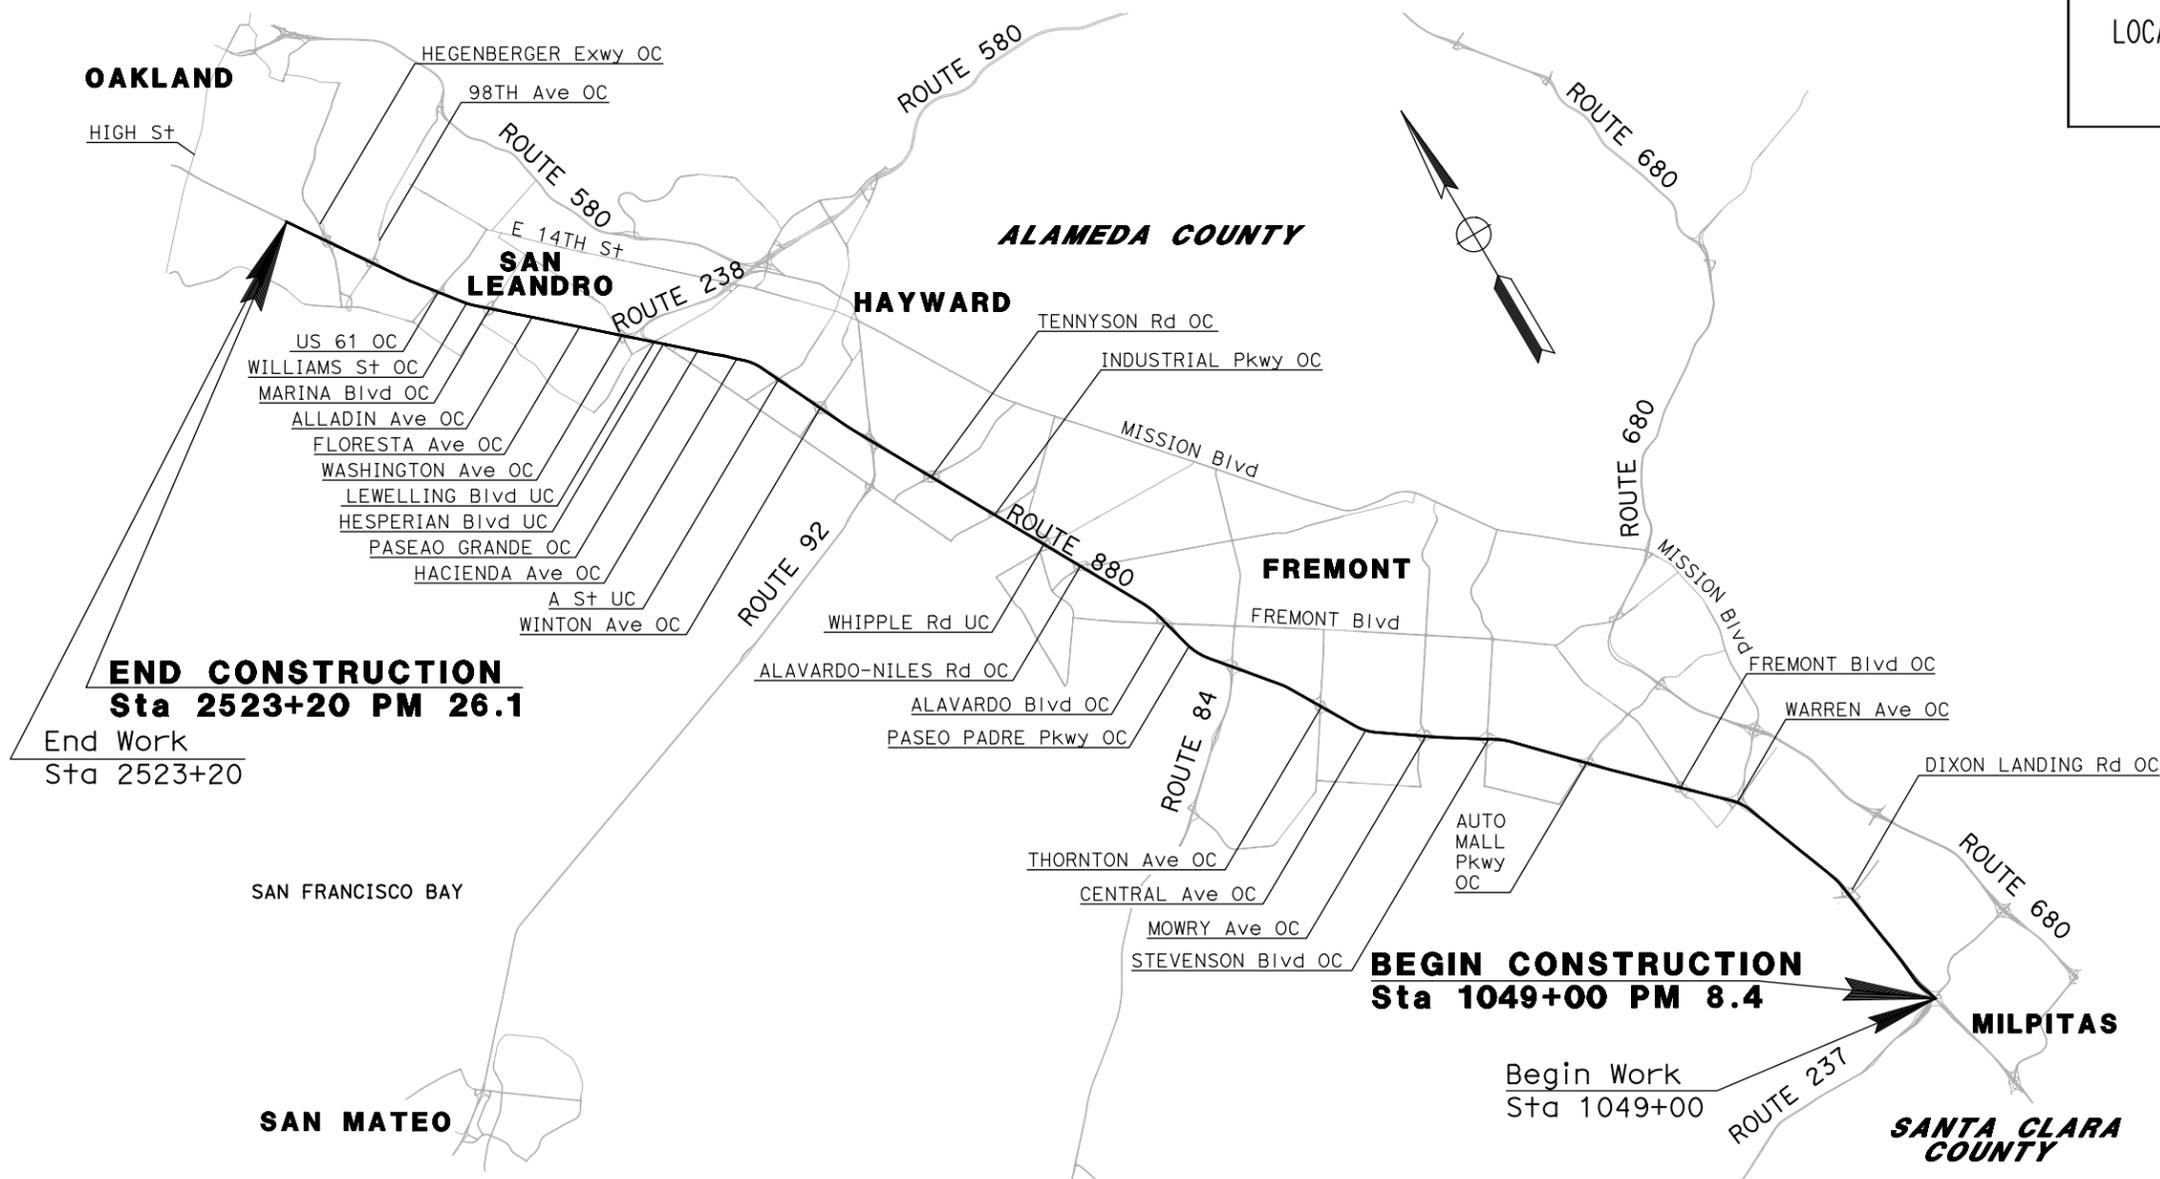

END CONSTRUCTION
Sta 2523+20 PM 26.1
 End Work
 Sta 2523+20

BEGIN CONSTRUCTION
Sta 1049+00 PM 8.4
 Begin Work
 Sta 1049+00

NO SCALE

PROJECT ENGINEER DATE
 REGISTERED CIVIL ENGINEER

PLANS APPROVAL DATE
 THE STATE OF CALIFORNIA OR ITS OFFICERS OR AGENTS SHALL NOT BE RESPONSIBLE FOR THE ACCURACY OR COMPLETENESS OF SCANNED COPIES OF THIS PLAN SHEET.

ATKINS
 332 PINE STREET
 5TH FLOOR
 SAN FRANCISCO, CA 94104

METROPOLITAN TRANSPORTATION COMMISSION
 101 EIGHTH STREET
 OAKLAND, CA 94607

CONTRACT No.	XX-XXXX
PROJECT ID	XXXXXXXX

APPROVED AS TO IMPACT ON STATE FACILITIES AND CONFORMANCE WITH APPLICABLE STATE STANDARDS AND PRACTICES AND THAT TECHNICAL OVERSIGHT WAS PERFORMED.
 DATE SIGNED
 LICENSE Exp DATE
 REGISTRATION No.
 CALTRANS DESIGN OVERSIGHT APPROVAL
 CONSULTANT DESIGN ENGINEER
 ARON ZEREZCHI

LAST REVISION
 00-00-00
 DATE PLOTTED => \$DATE
 TIME PLOTTED => \$TIME